



1 Level 14 - Floor Layout Plan

1 : 100

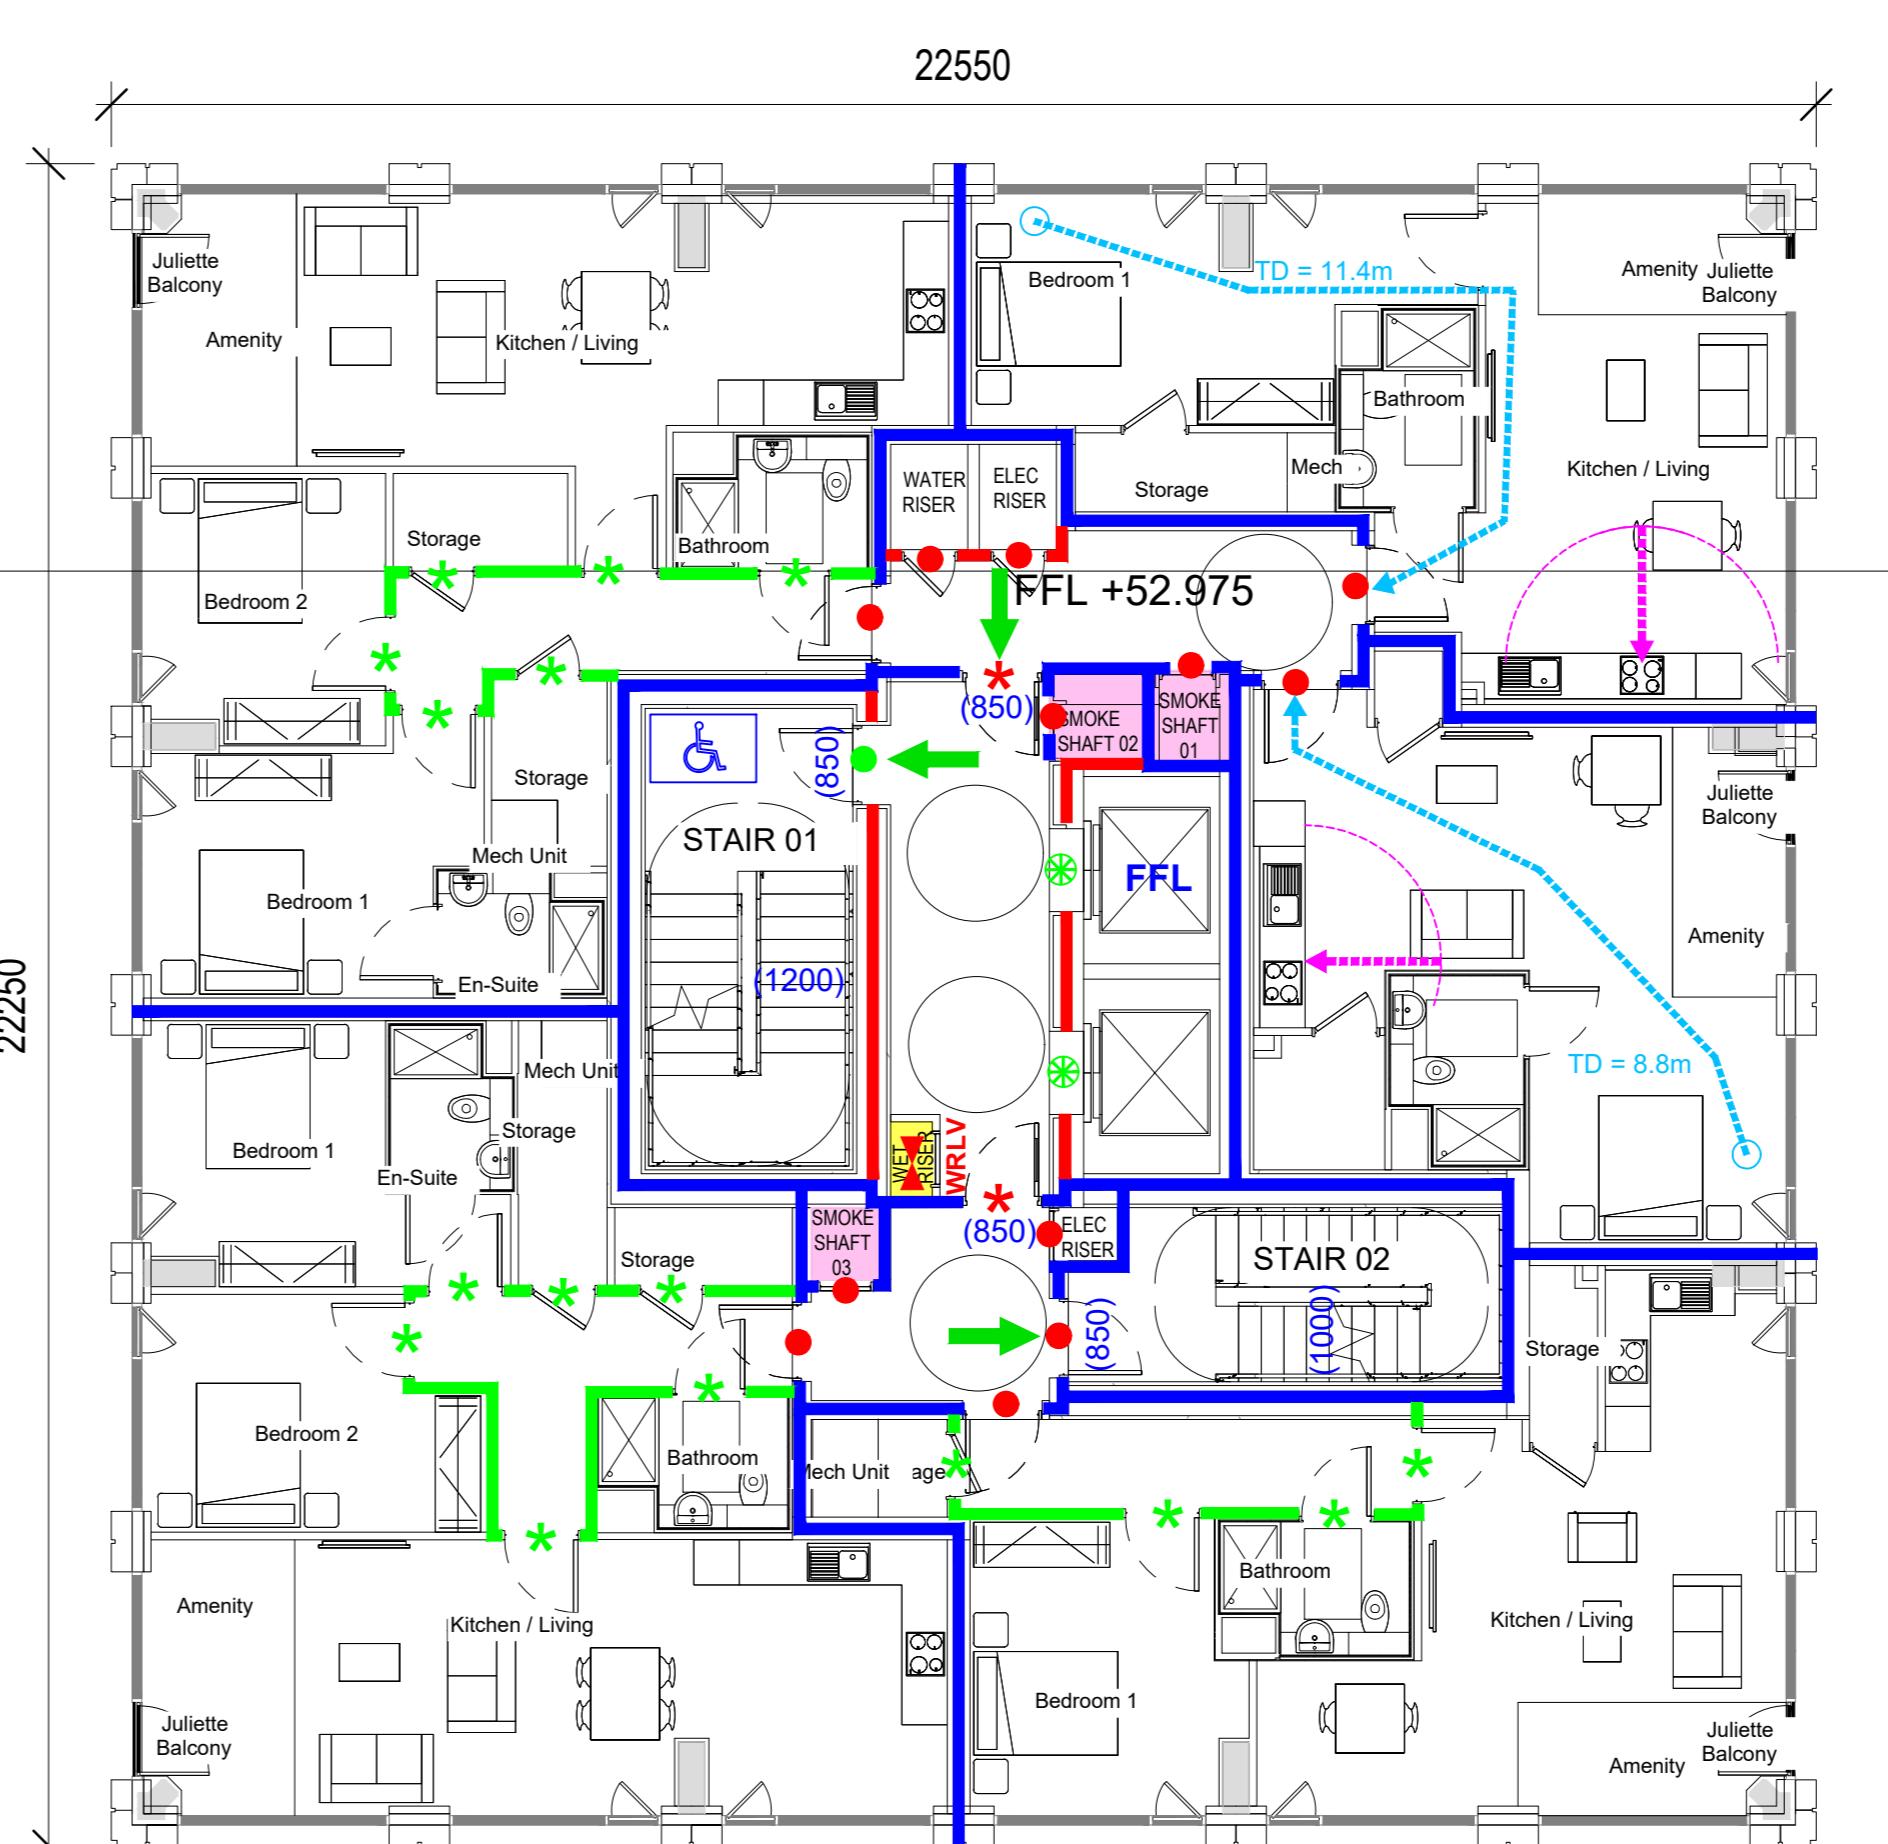


Level 15 - Floor Layout Plan

2 $\frac{1:100}$

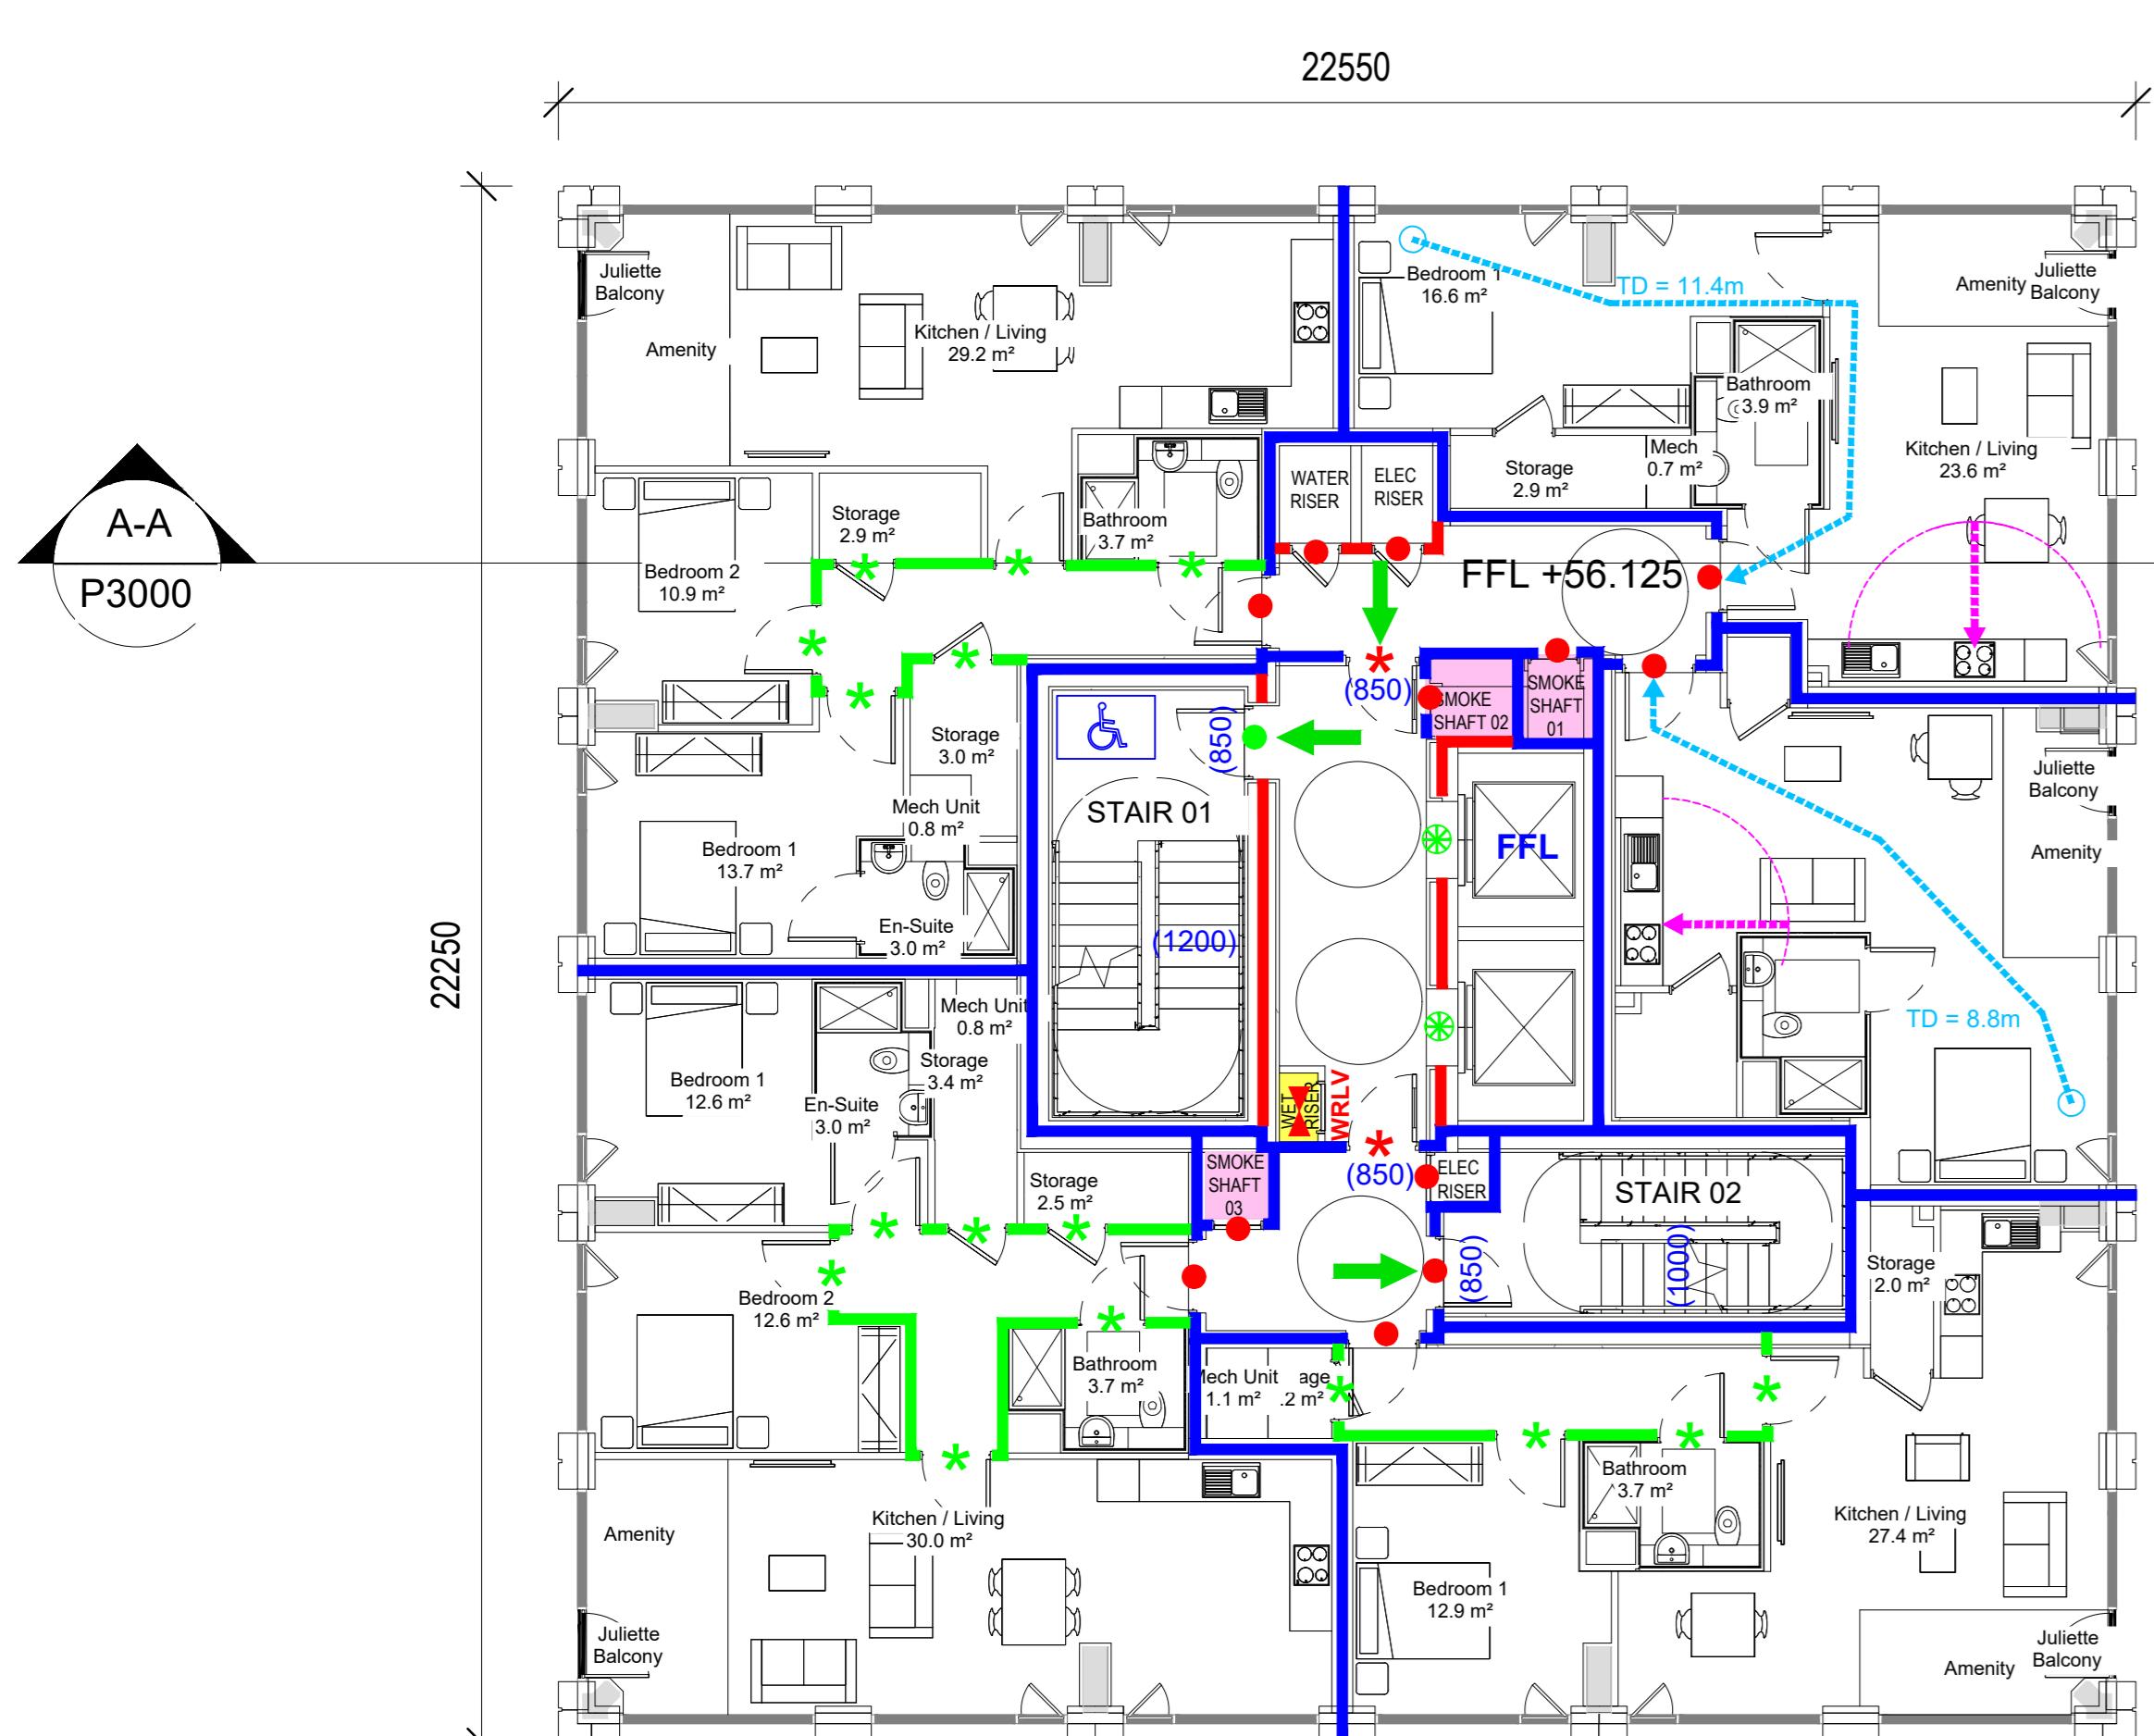


1 Level 16 - Floor Layout Plan

1 : 100

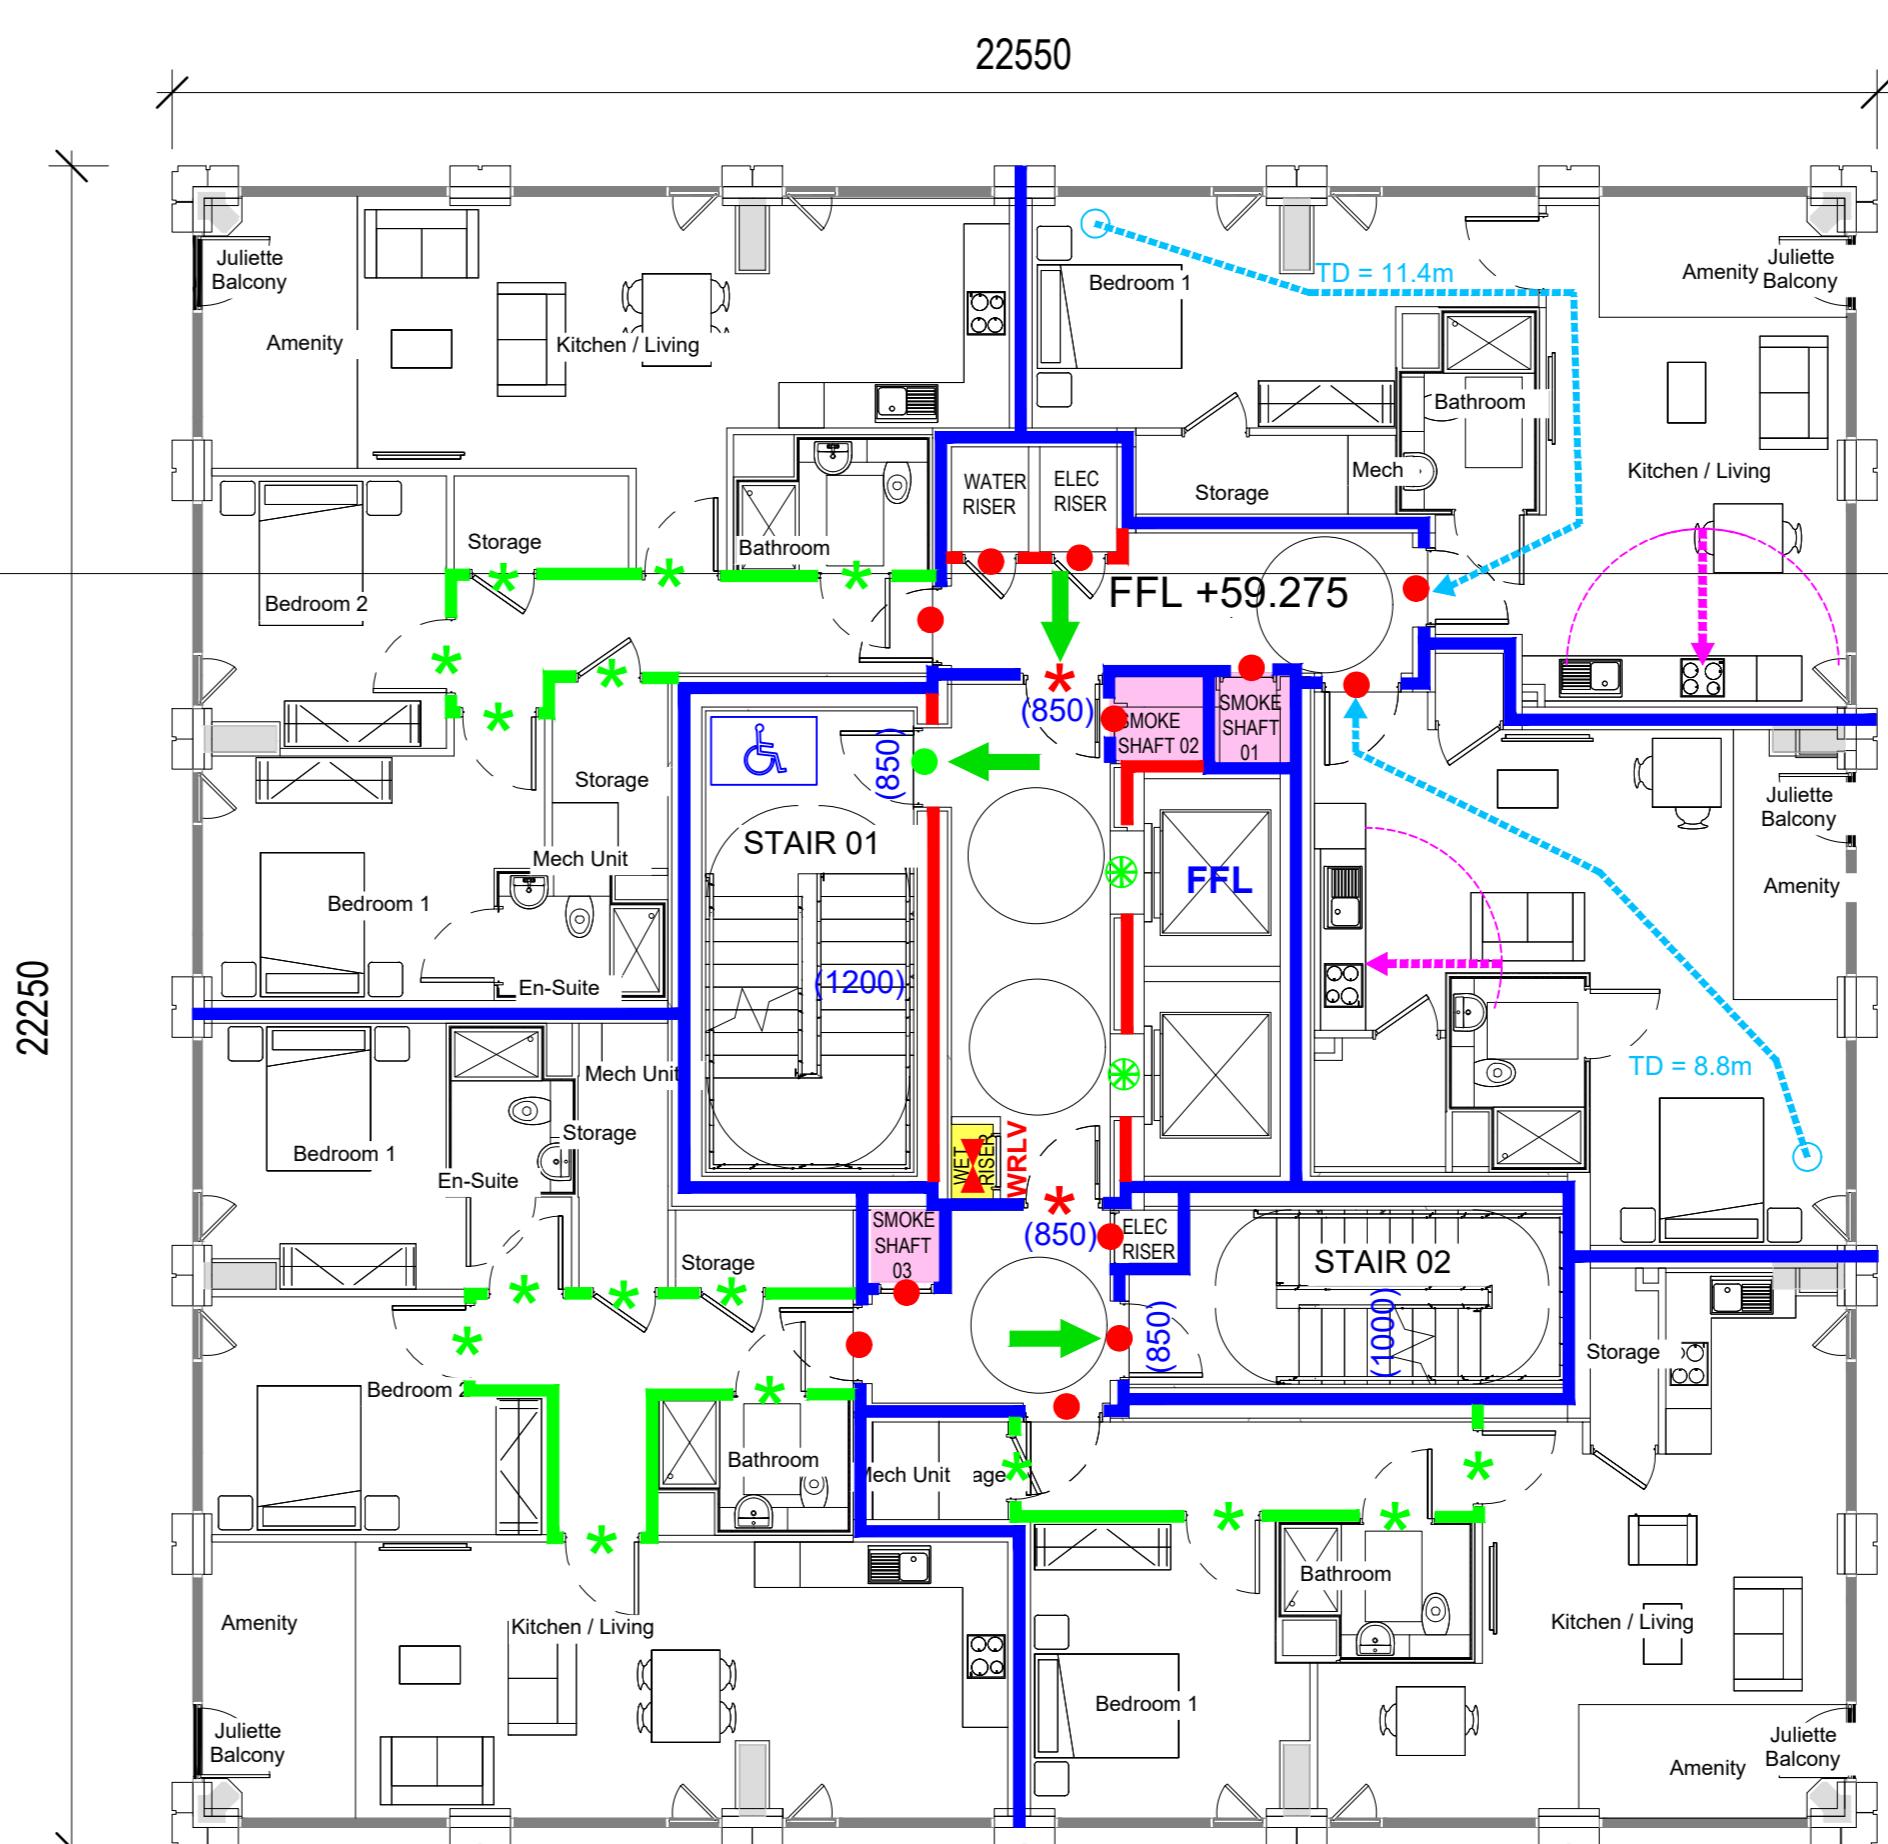

2 Level 17 - Floor Layout Plan

$$2 \frac{1:100}{}$$

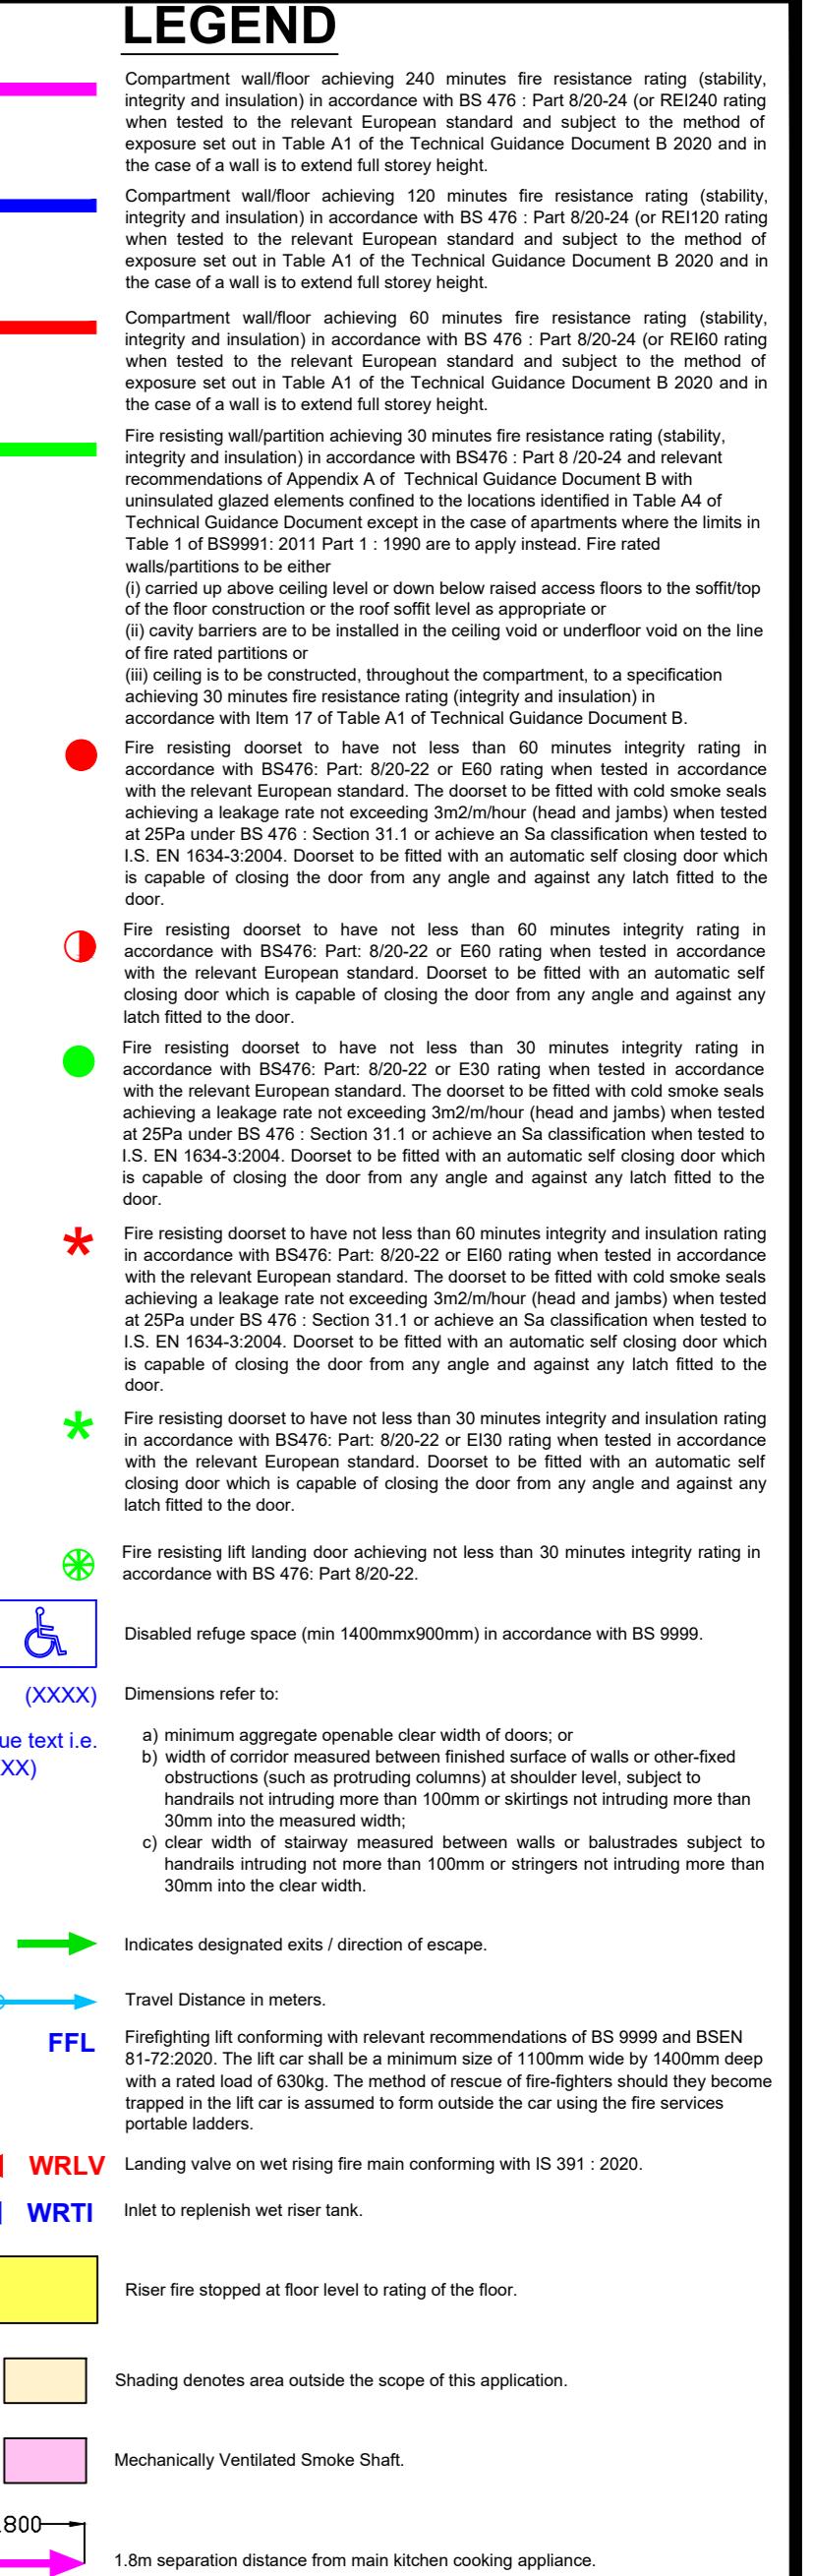

SC Application

A	MINOR AMENDMENTS	02.04.2024
REV.	DESCRIPTION	DATE
 <p>Michael Slattery Associates Fire Safety Engineers</p> <p>www.msa.ie</p> <p>9 Windsor Place Lower Pembroke Place Dublin 2, Ireland Tel: +353(1)6765713 Fax: +353(1)6785247</p> <ul style="list-style-type: none"> > Building Design & Construction > Fire Engineering Design > Event Safety & Management > Building Fire Safety Management > Disabled Access Consultancy > Computer Modelling 		
<p>PROJECT ALBERT QUAY</p> <p>FIRE SAFETY CERTIFICATE</p> <p>TITLE FOURTEENTH, FIFTEENTH, SIXTEENTH & SEVENTEENTH FLOOR PLAN LEVEL 14, 15, 16 & 17</p> <p>SCALE 1:100 @ A0 JOB No 18446-3</p> <p>DATE 11.03.2024 DWG No 18446-3-16-FSC</p> <p>CHECKED BY REV A</p>		