


LEGEND OF SYMBOLS:

BS 8600:2018 PEDESTRIAN ACCESS ROUTE TO BE ILLUMINATED TO 5 LUX MINIMUM

- Z1 ■ PHILIPS DIGISTREET CATENARY BSP764 38W 5888 LUMENS. C/W ON BOARD PHOTOCELL & DRIVER
- Z2 ■■■ LINEAR LIGHTING FOR STEPS
- Z3 ■■■ RECESSED FEATURE UPLIGHTER
- Z4 ■■■ FLUSH RECESSED GROUND LINEAR STRIP LIGHTING
- Z5 ■■■■■ FEATURE UPLIGHT STRIP
- 4M POLE STRUCTURE TO SUPPORT LUMINAIRE C/W MAINTENANCE HATCH AT 1400mm
- SUPPLY CIRCUIT
- Ø12mm SUPPLY CABLE FROM POLE SUPPORT STRUCTURE
- PL ■■■■■ PUBLIC LIGHTING MINI PILLAR TO FEED FITTINGS FROM POLE SUPPORT STRUCTURE
- ESB ■■■■■ 125mm ESB DUCT
- PL ■■■■■ 110mm PUBLIC LIGHTING DUCT
- ESB ■■■■■ ESB MINI PILLAR



REF: Z1 LUMINAIRE
PHILIPS DIGISTREET CATENARY BSP764 38W 5888 LUMENS.
1 LAMP PER LUMINAIRE. 1400 INITIAL LUMENS PER LAMP.
DRIVER TYPE = XI FP 75W 0.2-0.7A SNLDAE 230V S240 sXT
MOUNTING HEIGHT = 4M
NUMBER LOCATIONS = 11 NUMBER

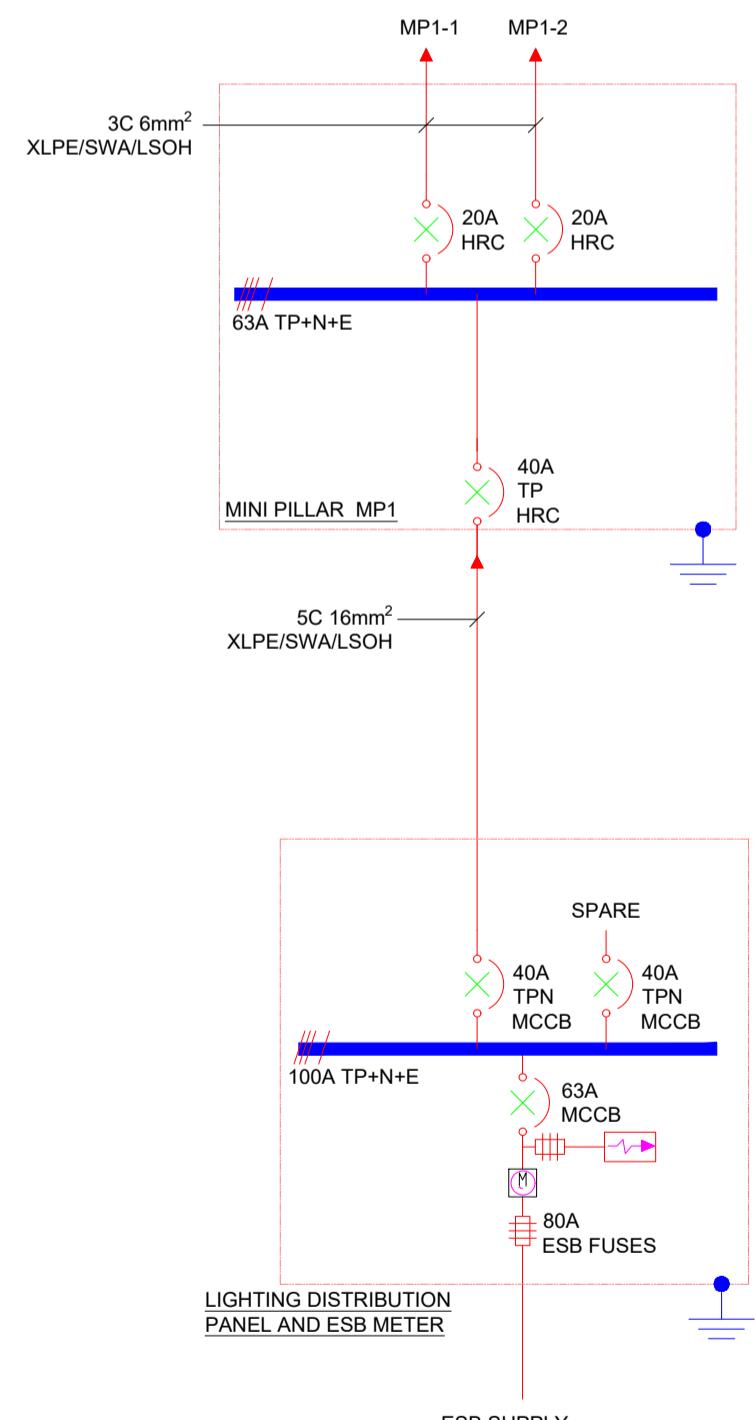

- FOR SETTING OUT REFER TO ARCHITECT'S DRAWINGS.
- THIS DRAWING TO BE READ IN CONJUNCTION WITH ALL OTHER ARCHITECTURAL AND ENGINEERING DRAWINGS AND ALL OTHER RELEVANT DRAWINGS AND SPECIFICATIONS.
- DO NOT SCALE THIS DRAWING. USE FIGURED DIMENSIONS ONLY.
- NO PART OF THIS DOCUMENT MAY BE REPRODUCED OR TRANSMITTED IN ANY FORM OR STORED IN ANY RETRIEVAL SYSTEM OF ANY NATURE WITHOUT THE WRITTEN PERMISSION OF O'CONNOR SUTTON CRONIN AS COPYRIGHT HOLDER EXCEPT AS AGREED FOR USE ON THE PROJECT FOR WHICH THE DOCUMENT WAS ORIGINALLY ISSUED.

Rev No.	Date	Revision Note	Drn by	Chkd by
P01	29.01.20	SUITABLE FOR PLANNING	B.O.B.	E.O.
P02	17.06.21	REVISED FOR PLANNING	B.O.B.	E.O.

Rev No.	Date	Revision Note	Drn by	Chkd by



Head Office,
9 Prussia Street,
Dublin 7,
D07 KT57

TEL +353 (0) 8682000

e: contactus@ocsc.ie

w: www.ocsc.ie

Dublin | London | Belfast | Galway | Cork | Birmingham



Client: CORK CITY COUNCIL
Project: BISHOP LUCEY PARK,
CORK CITY
Title: ELECTRICAL
SITE LIGHTING LAYOUT
GROUND FLOOR PLAN
Code | Originator | Zone | Level | Type | Role | Number | Status | Revision
H648 - OCSC - XX - XX - DR - E - 0001 | S8 | P02
Date: 10.02.20 Scale: 1:250 | At 1 Drn by: B.O.B. Chkd by: B.O.B. Aprov'd by: E.O.